

125.0

10' UE

25' BL

LOT 34 BLOCK 1
DEERWOOD ESTATES
KILLEEN, TX

NEW
25x50
BLDG

8'

25'

212.0

CONC
DRIVE

197.49

EXISTING
WILSON RESIDENCE


20'


68'-8"

36'


25' BL

35'

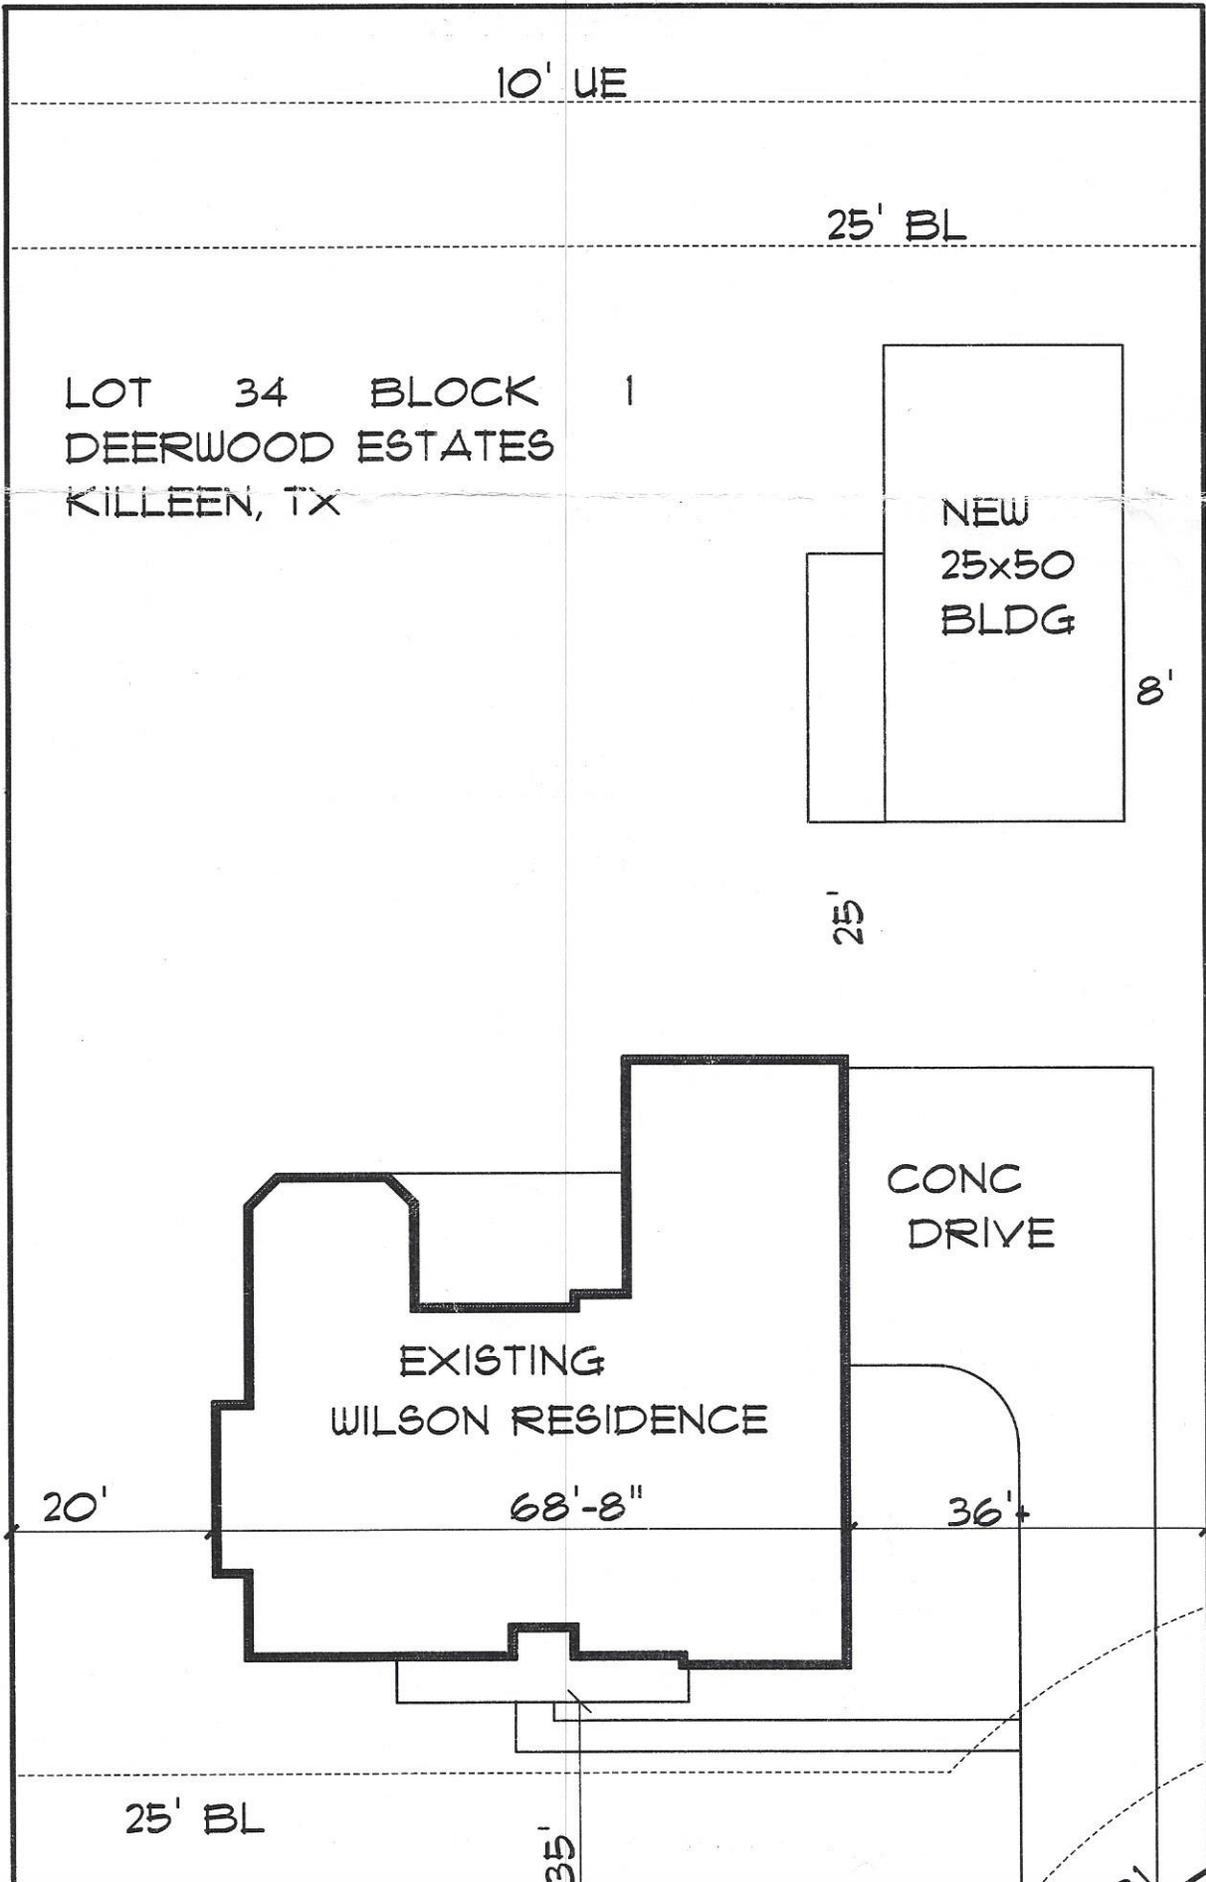


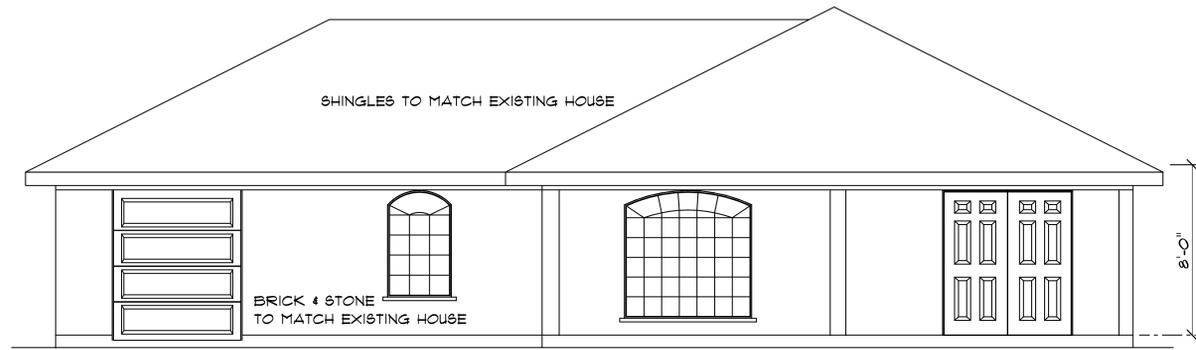

FRONT

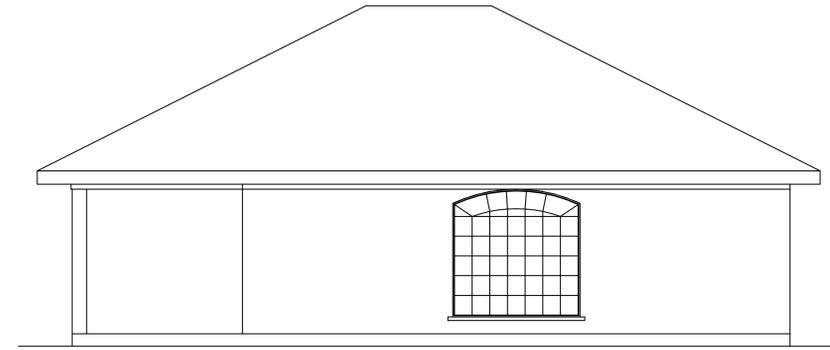


RIGHT SIDE

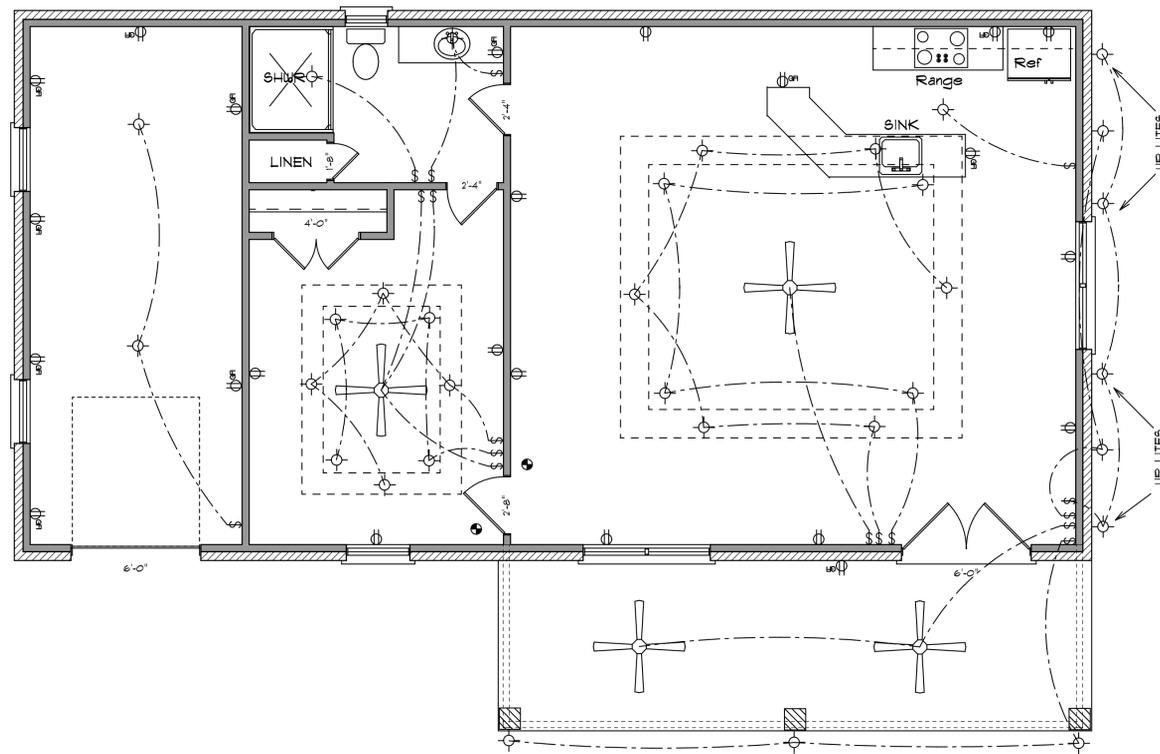

ELECTRICAL LAYOUT

SCALE: 1/4" = 1'-0"

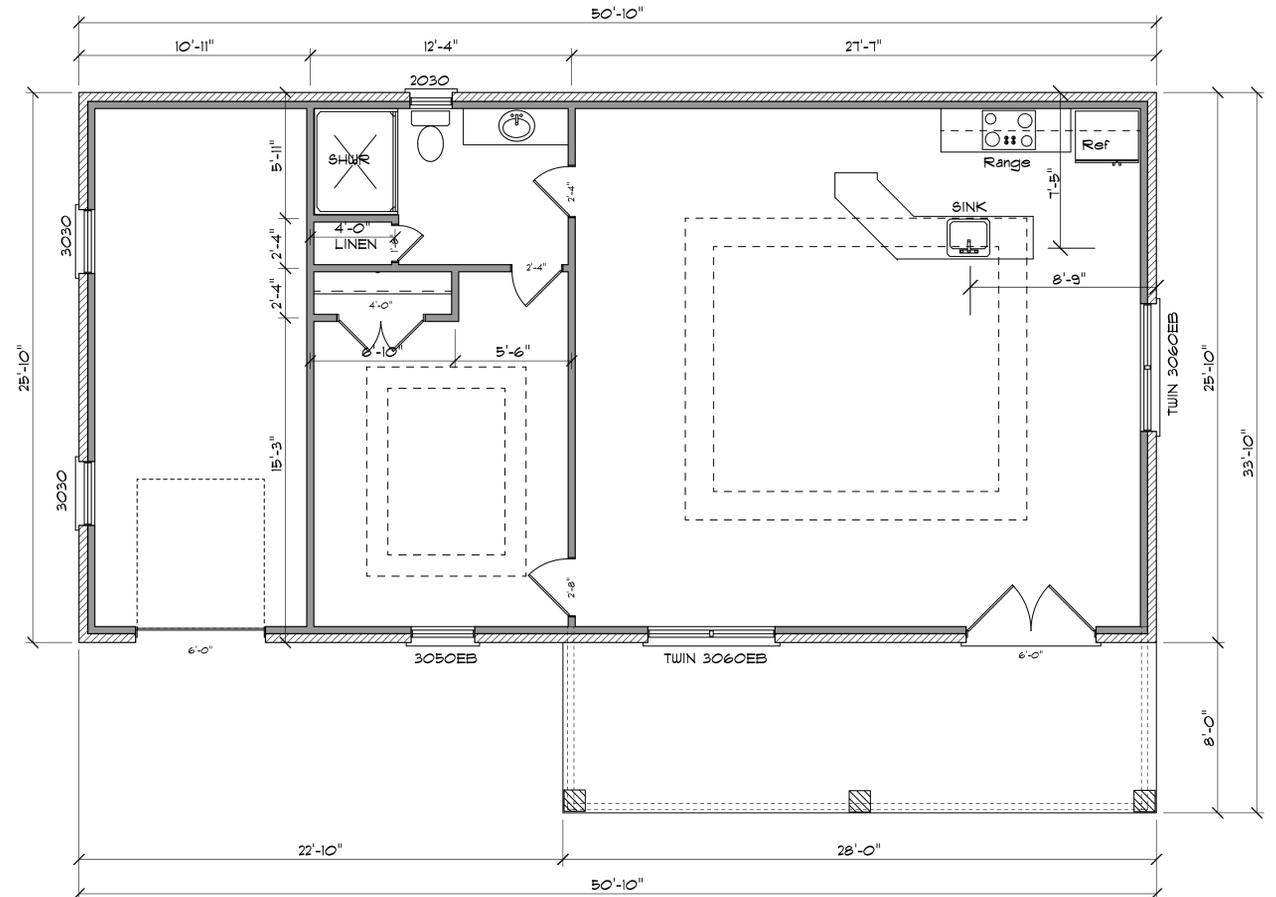

FLOOR PLAN

SCALE: 1/4" = 1'-0"

TODD WILSON
4901 DEERWOOD LOOP